


INSPECTOR
 Zoning Inspector
 William J. ...
 # 6999
 This Permit started 8-22-87
 ZONING APPROVED
 PAINESVILLE TOWNSHIP

SEWAGE DISPOSAL PERMIT MUST BE OBTAINED BY A LAKE COUNTY LICENSED INSTALLER BEFORE INSTALLATION IS STARTED.

Reviewed and Accepted
 LAKE COUNTY GENERAL HEALTH DISTRICT
 Date 5-15-87
 JOEL LUCIA, R. S., M. P. H.
 Health Commissioner
 BY: [Signature]

LOW YIELD WATER
 FIXTURES REQUIRED
 ON ALL:
 Shower Head
 Toilet

- A. To be brought to finished grade
1. Septic tank manhole covers
 2. Spitter box cover
 3. Distribution box cover
 4. Vent Pipes
- B. No floor drains or downspouts to be discharged into septic tanks
- C. All waste water to be discharged into septic tanks

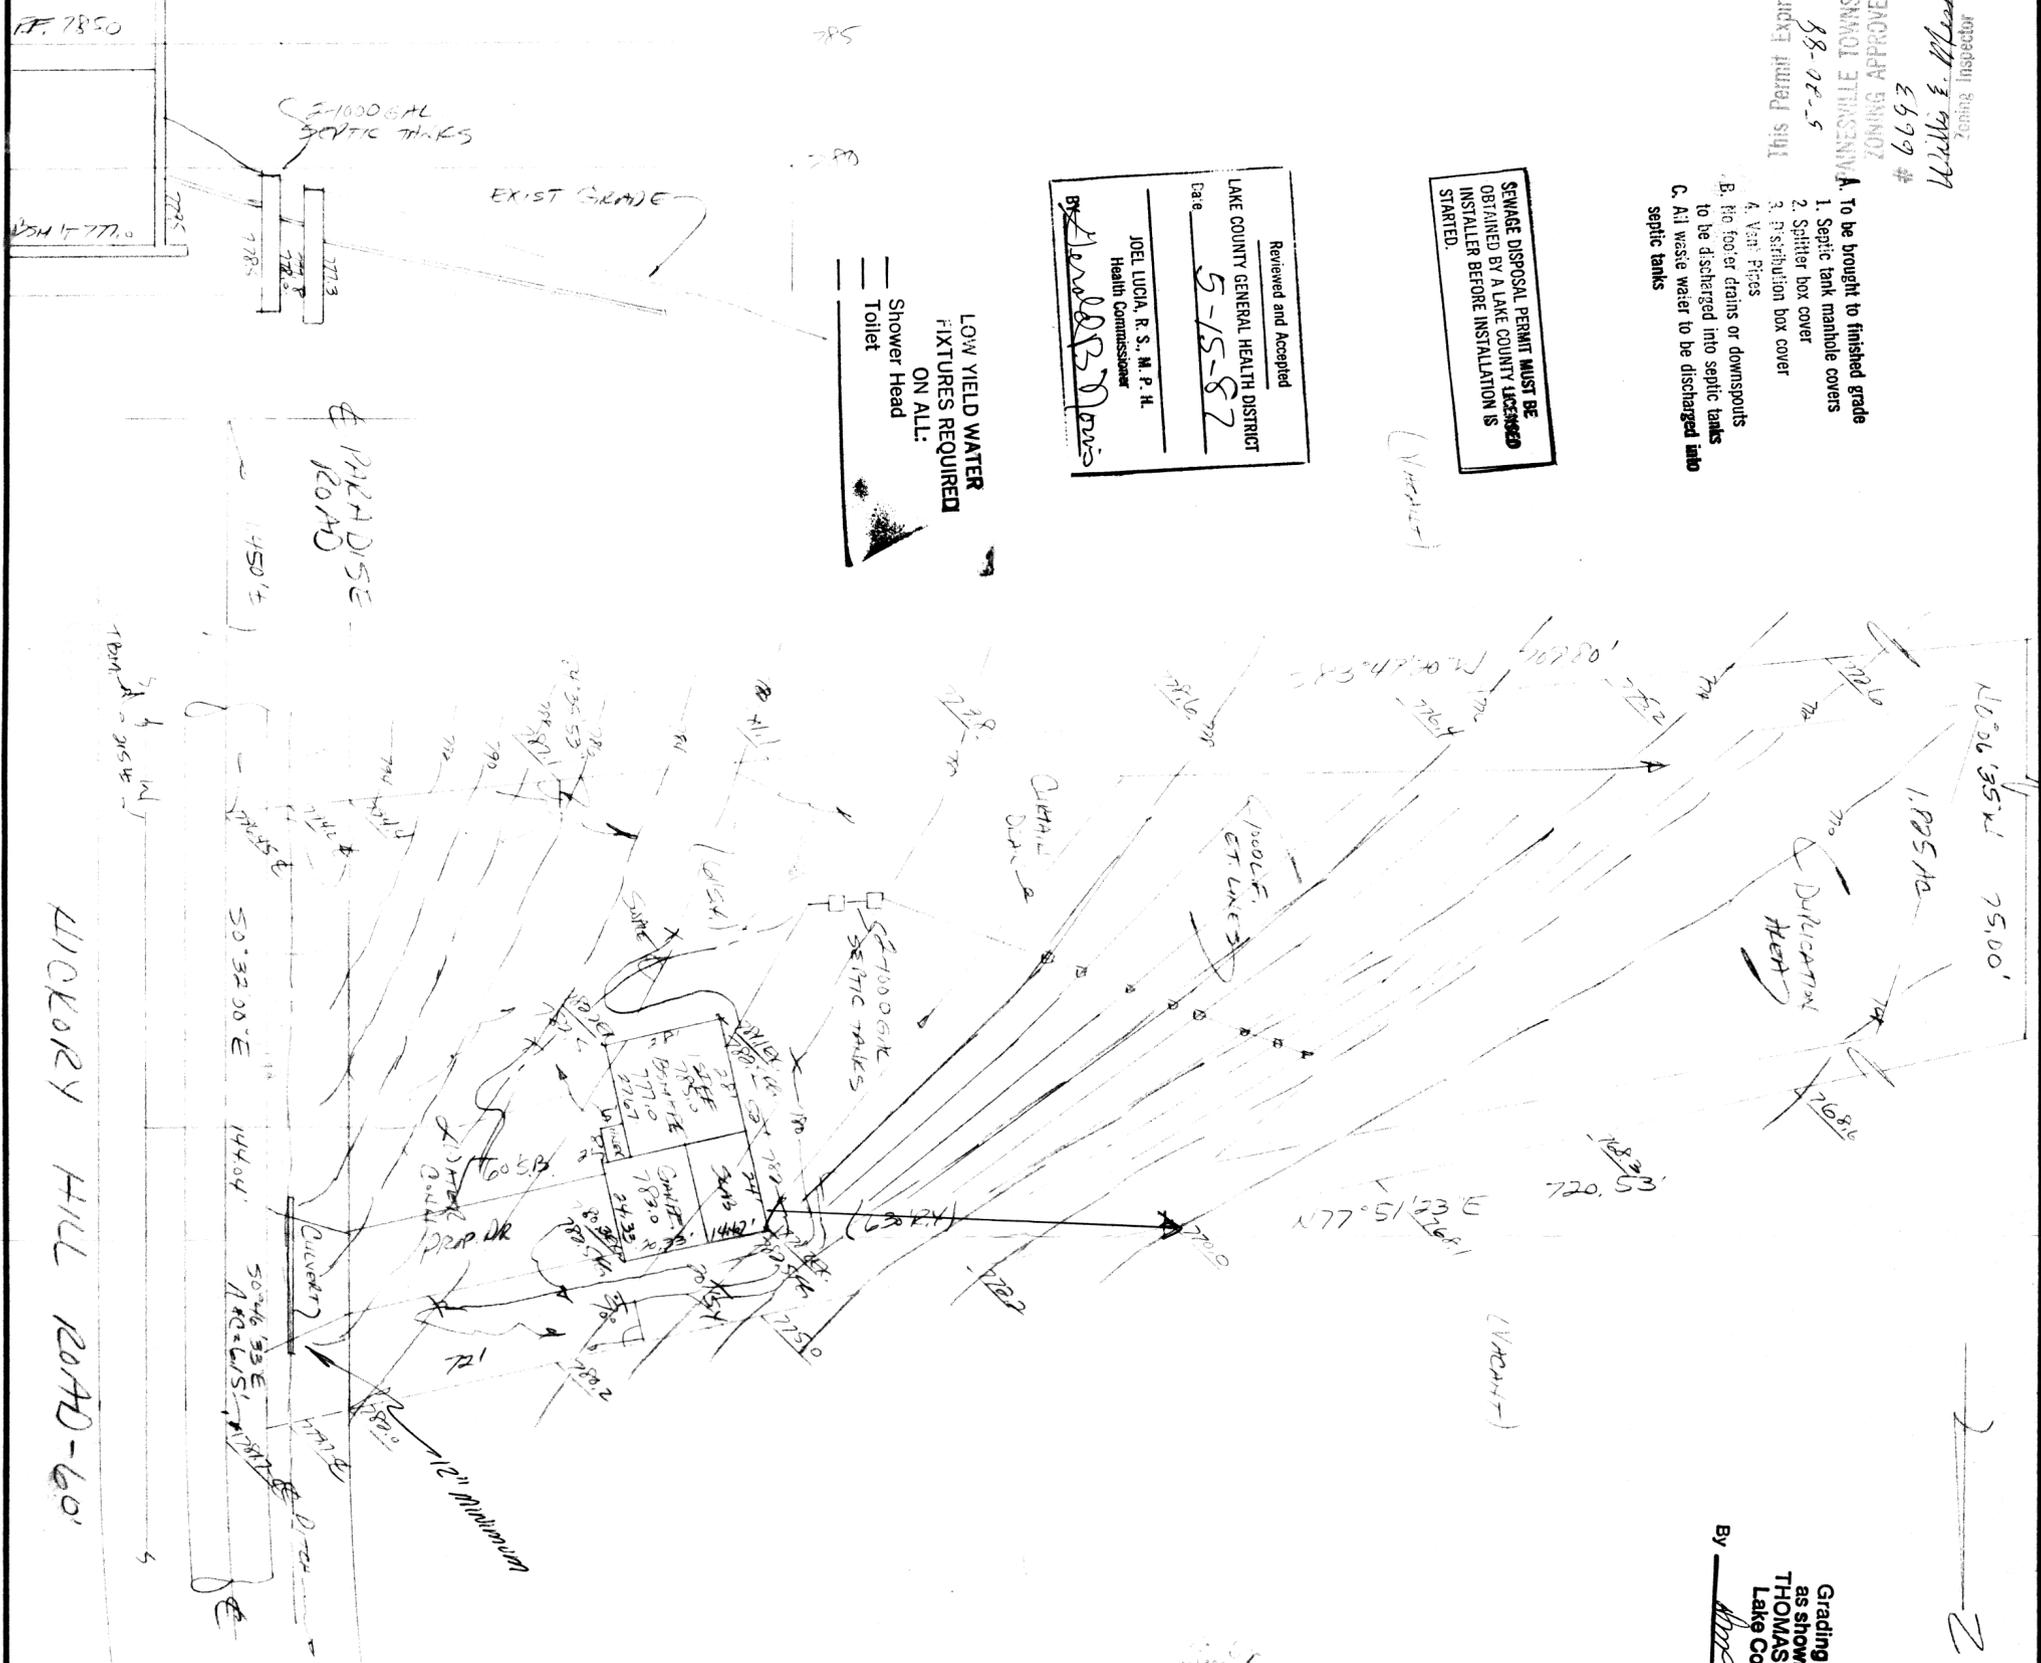

Grading Plan Approved
 as shown and/or noted
 THOMAS P. GILLES, P.E.
 Lake County Engineer
 By: [Signature] Date 6-22-87



SITE PLAN

PAINESVILLE TOWNSHIP LAKE COUNTY, OHIO
for: SHYMKOE COLLECTIVE
 CLIENT OWNER

ADDRESS STREET CITY ZIP
 SUBDIVISION VOL. - PG. NAME LOT # 28 TRACT # 880
 SUBLOT NO. STREET VOLUME 1-44 PAGE 880
 PERM. PARCEL NO. HIGHWAY NO. STREET

LEGEND

○	WATER VALVE (GAS)	→	INDICATES DIRECTION OF SURFACE DRAINAGE
●	WATER METER (GAS)	---	AS BUILT ELEVATION
○	MANHOLE	---	EXISTING CONTOURS
○	STORM	---	PROPOSED CONTOURS
○	INLET OR CATCH BASIN	---	EXIST. ELEV. 100.0
○	HYDRANT	---	PROP. ELEV. 100.0

REMARKS
 ALL BOUNDARY DATA SHOWN WAS OBTAINED FROM IDEEDS, RECORDED SUBDIVISION PLAT OR OTHER PUBLIC RECORDS.
 LOCATIONS AS SHOWN OF ADJACENT WELLS AND SEPTIC TANKS OBTAINED FROM LAKE COUNTY HEALTH DEPARTMENT

DESIGN CERTIFICATION
 THIS PLAN WAS PREPARED BY ME, AND IS CORRECT TO THE BEST OF MY KNOWLEDGE AND BELIEF.
 NAME SURVEYOR REGISTRATION NO. HARRY S. JONES, JR. S-6343

CHECK LIST

NO. OF BEDROOMS	WATER MAIN SIZE	LOCATION
DIMENSIONS	SAN. SEWER SIZE	% GR. LOC.
BEARINGS	SAN. MH. CAST ELEV.	INV. ELEV.
TIE TO NEAREST STREET	SAN. CONN. SIZE	LOC. DEPTH
SUBLOT NO. PARCEL NO.	STORM SEWER SIZE	% GR. LOC.
SURROUNDING OWNERS	BLDG. DIMENSIONS	FIN. GR.
BLDG. DIMENSIONS	PAVT TYPE GRADE	CURBS
PAVT TYPE GRADES	APRON TYPE WIDTH	THICKNESS
SEPTIC TANK LOCATION	SEPTIC TANK LENGTH	& DUPLICATION AREA
WELL LOCATION	ISOLATION RADIUS	FROM WELL
ROCK OUTCROPPINGS		

PLAN PREPARED BY:
 BABCOCK • JONES & ASSOCIATES, INC.
 PAINESVILLE OHIO

NO.	DATE	BY	SCALE	PHONE NO.
1	5/14/87	HT	1" = 3'	357-1811
2				
3				
4				
5				

"AS BUILT" CERTIFICATION
 I, HEREBY CERTIFY THAT THE CIRCLED GRADES ARE EXISTING FINISH GRADES CHECKED IN THE FIELD ON 19 19
 AND ARE CORRECT TO THE BEST OF MY KNOWLEDGE AND BELIEF.
 REGISTERED SURVEYOR REG. NO. 7819 - 2nd 2nd Survey of Painesville, Ohio Elev = 810.0