

SITE PLAN

for : McCullough Builders
CLIENT
P.O. Box 349 Perry Ohio 44081
ADDRESS CITY STATE ZIP

61 Oakbrook Village Sub. Z 21
SUBLOT No. SUBDIVISION NAME VOL PAGE
48 Perry Twp. Ohio
LOT TRACT CITY STATE

Foresight Engineering Group



Engineers & Surveyors

440 288-1010
 440 288-1034 fax
 320 Center Street, Unit F
 Chardon, Ohio 44024

SCALE : 1" = 30'	1
FILE NAME: I:\McC10301\Field	2
DATE : April 8, 2003	3

BENCHMARK: Top Stem of Fire Hydrant
 Elevation: 694.72 (as shown)

SHEET NO.
 1/2

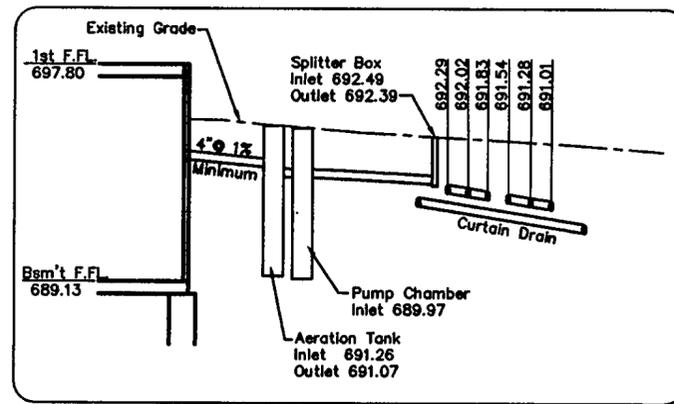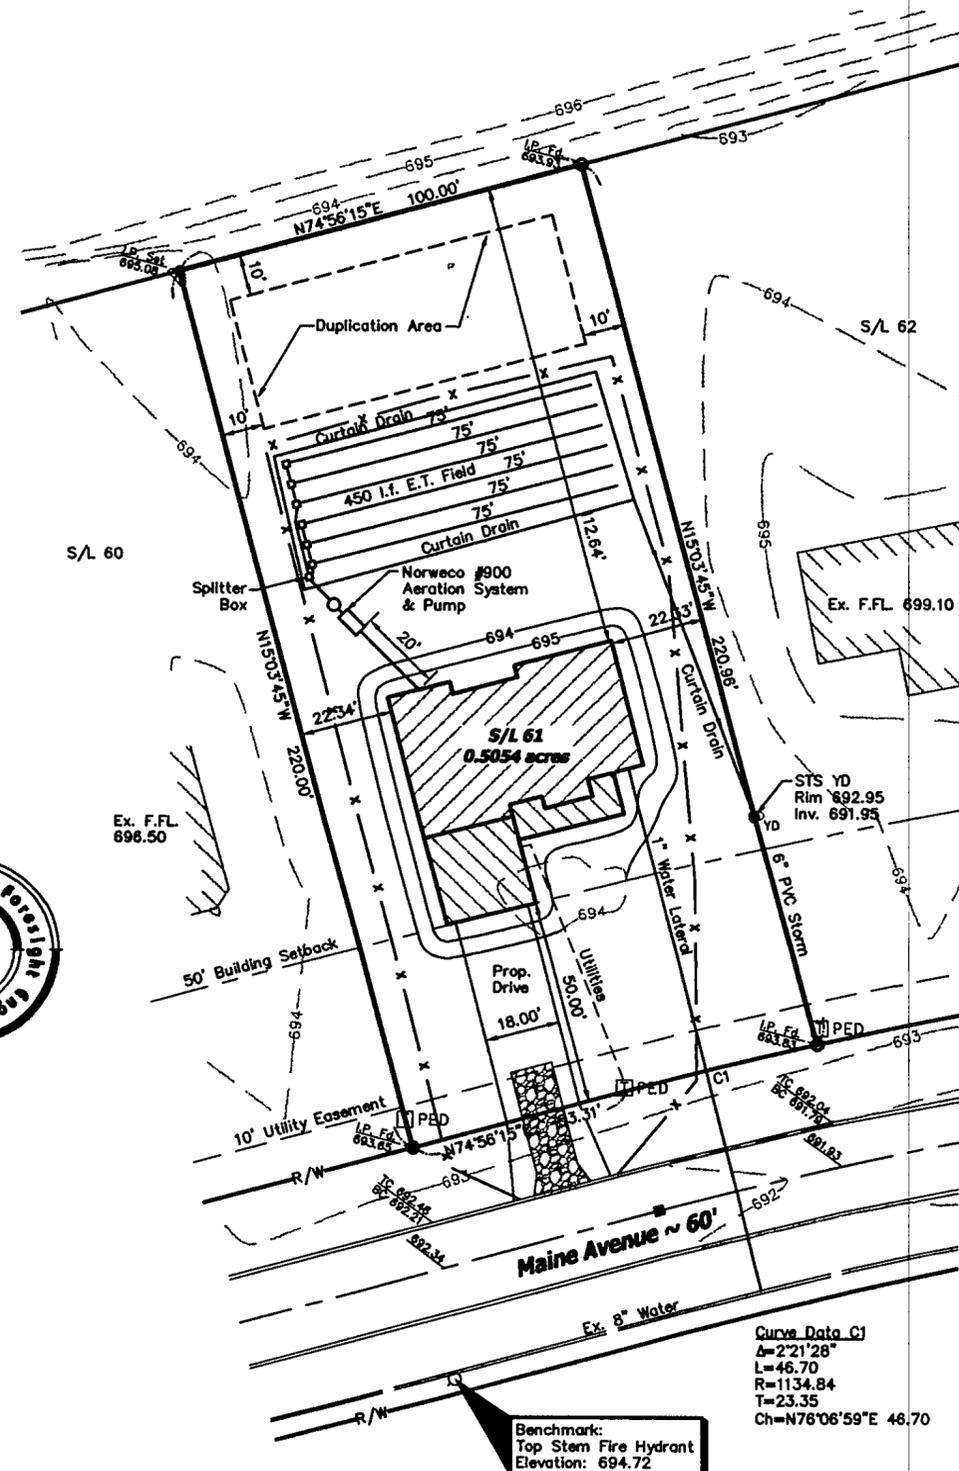

Hydraulic Profile
 NO SCALE

REVIEWED AND ACCEPTED
 LAKE COUNTY GENERAL
 HEALTH DISTRICT

Date 4-21-03 BY
Derald B. Morris

SEWAGE DISPOSAL PERMIT MUST BE
 OBTAINED BY A LAKE COUNTY LICENSED
 INSTALLER BEFORE INSTALLATION IS
 STARTED

Utilities include Gas line,
 Electric, Phone and Cable.
 Contractor to field verify
 location and provide
 connection at utility.



EROSION CONTROL SYMBOLS

Zoning District ~ R1
 Front Setback 50'
 Side Setback 15'
 Rear Setback 15'

— x — x — Silt Fence
 Construction Entrance

SYMBOL LEGEND

	Fire Hydrant
	Iron Pin Found
	Iron Pin Monument Found
	Iron Pin Set
	Yard Drain
	Telephone Box
	Electrical Box

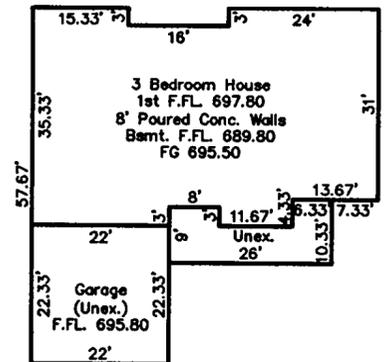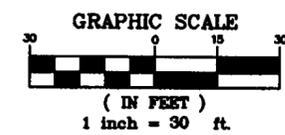

Grading Plan Approved
 as shown and/or noted
 JAMES R. GILLS, P.E.
 Lake County Engineer
 By AMJ Date 4/25/03




Curve Data C1
 Δ=221°28'
 L=46.70
 R=1134.84
 T=23.35
 Ch=N78°06'59"E 46.70

"I, the undersigned hereby certify that this topography,
 indicated by 1" contours, and the elevations shown hereon
 represent an actual field survey made by Foresight
 Engineering Group, Inc. on the 1 day of April, 2003 and
 that the elevations were taken at appropriate intervals and
 that as of that date they existed as indicated hereon."

The locations of the underground utilities as shown hereon are based
 on above ground structures and record drawings. Locations of
 underground utilities/structures may vary from the locations shown
 hereon. Additional buried utilities/structures may be encountered.
 Contractor to field verify horizontal and vertical location of all
 utilities in all area of work prior to commencement of work.

**2 WORKING DAYS
 BEFORE YOU DIG**

CALL TOLL FREE 800-362-2764
 OHIO UTILITIES PROTECTION SERVICE

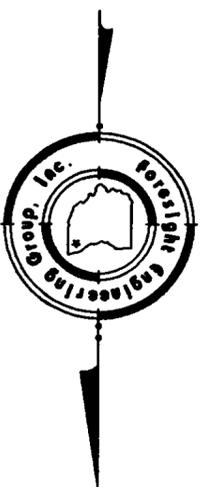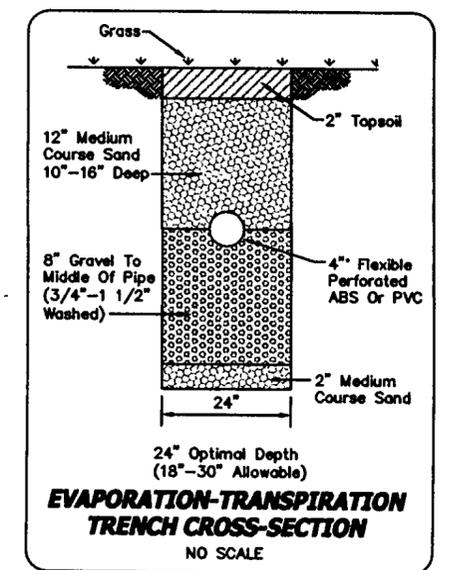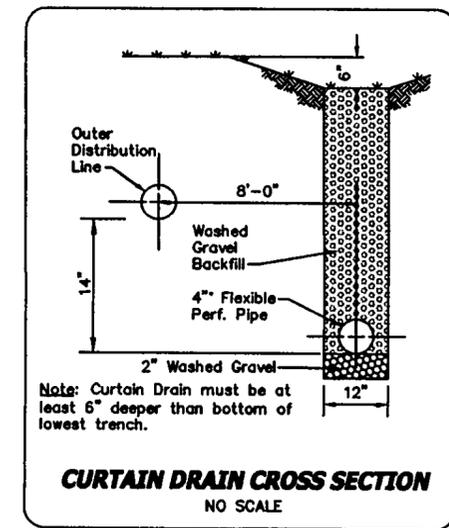

Steven N. Roessner
 NAME